


INDICATIVE ONLY

AGRICULTURAL FIELD

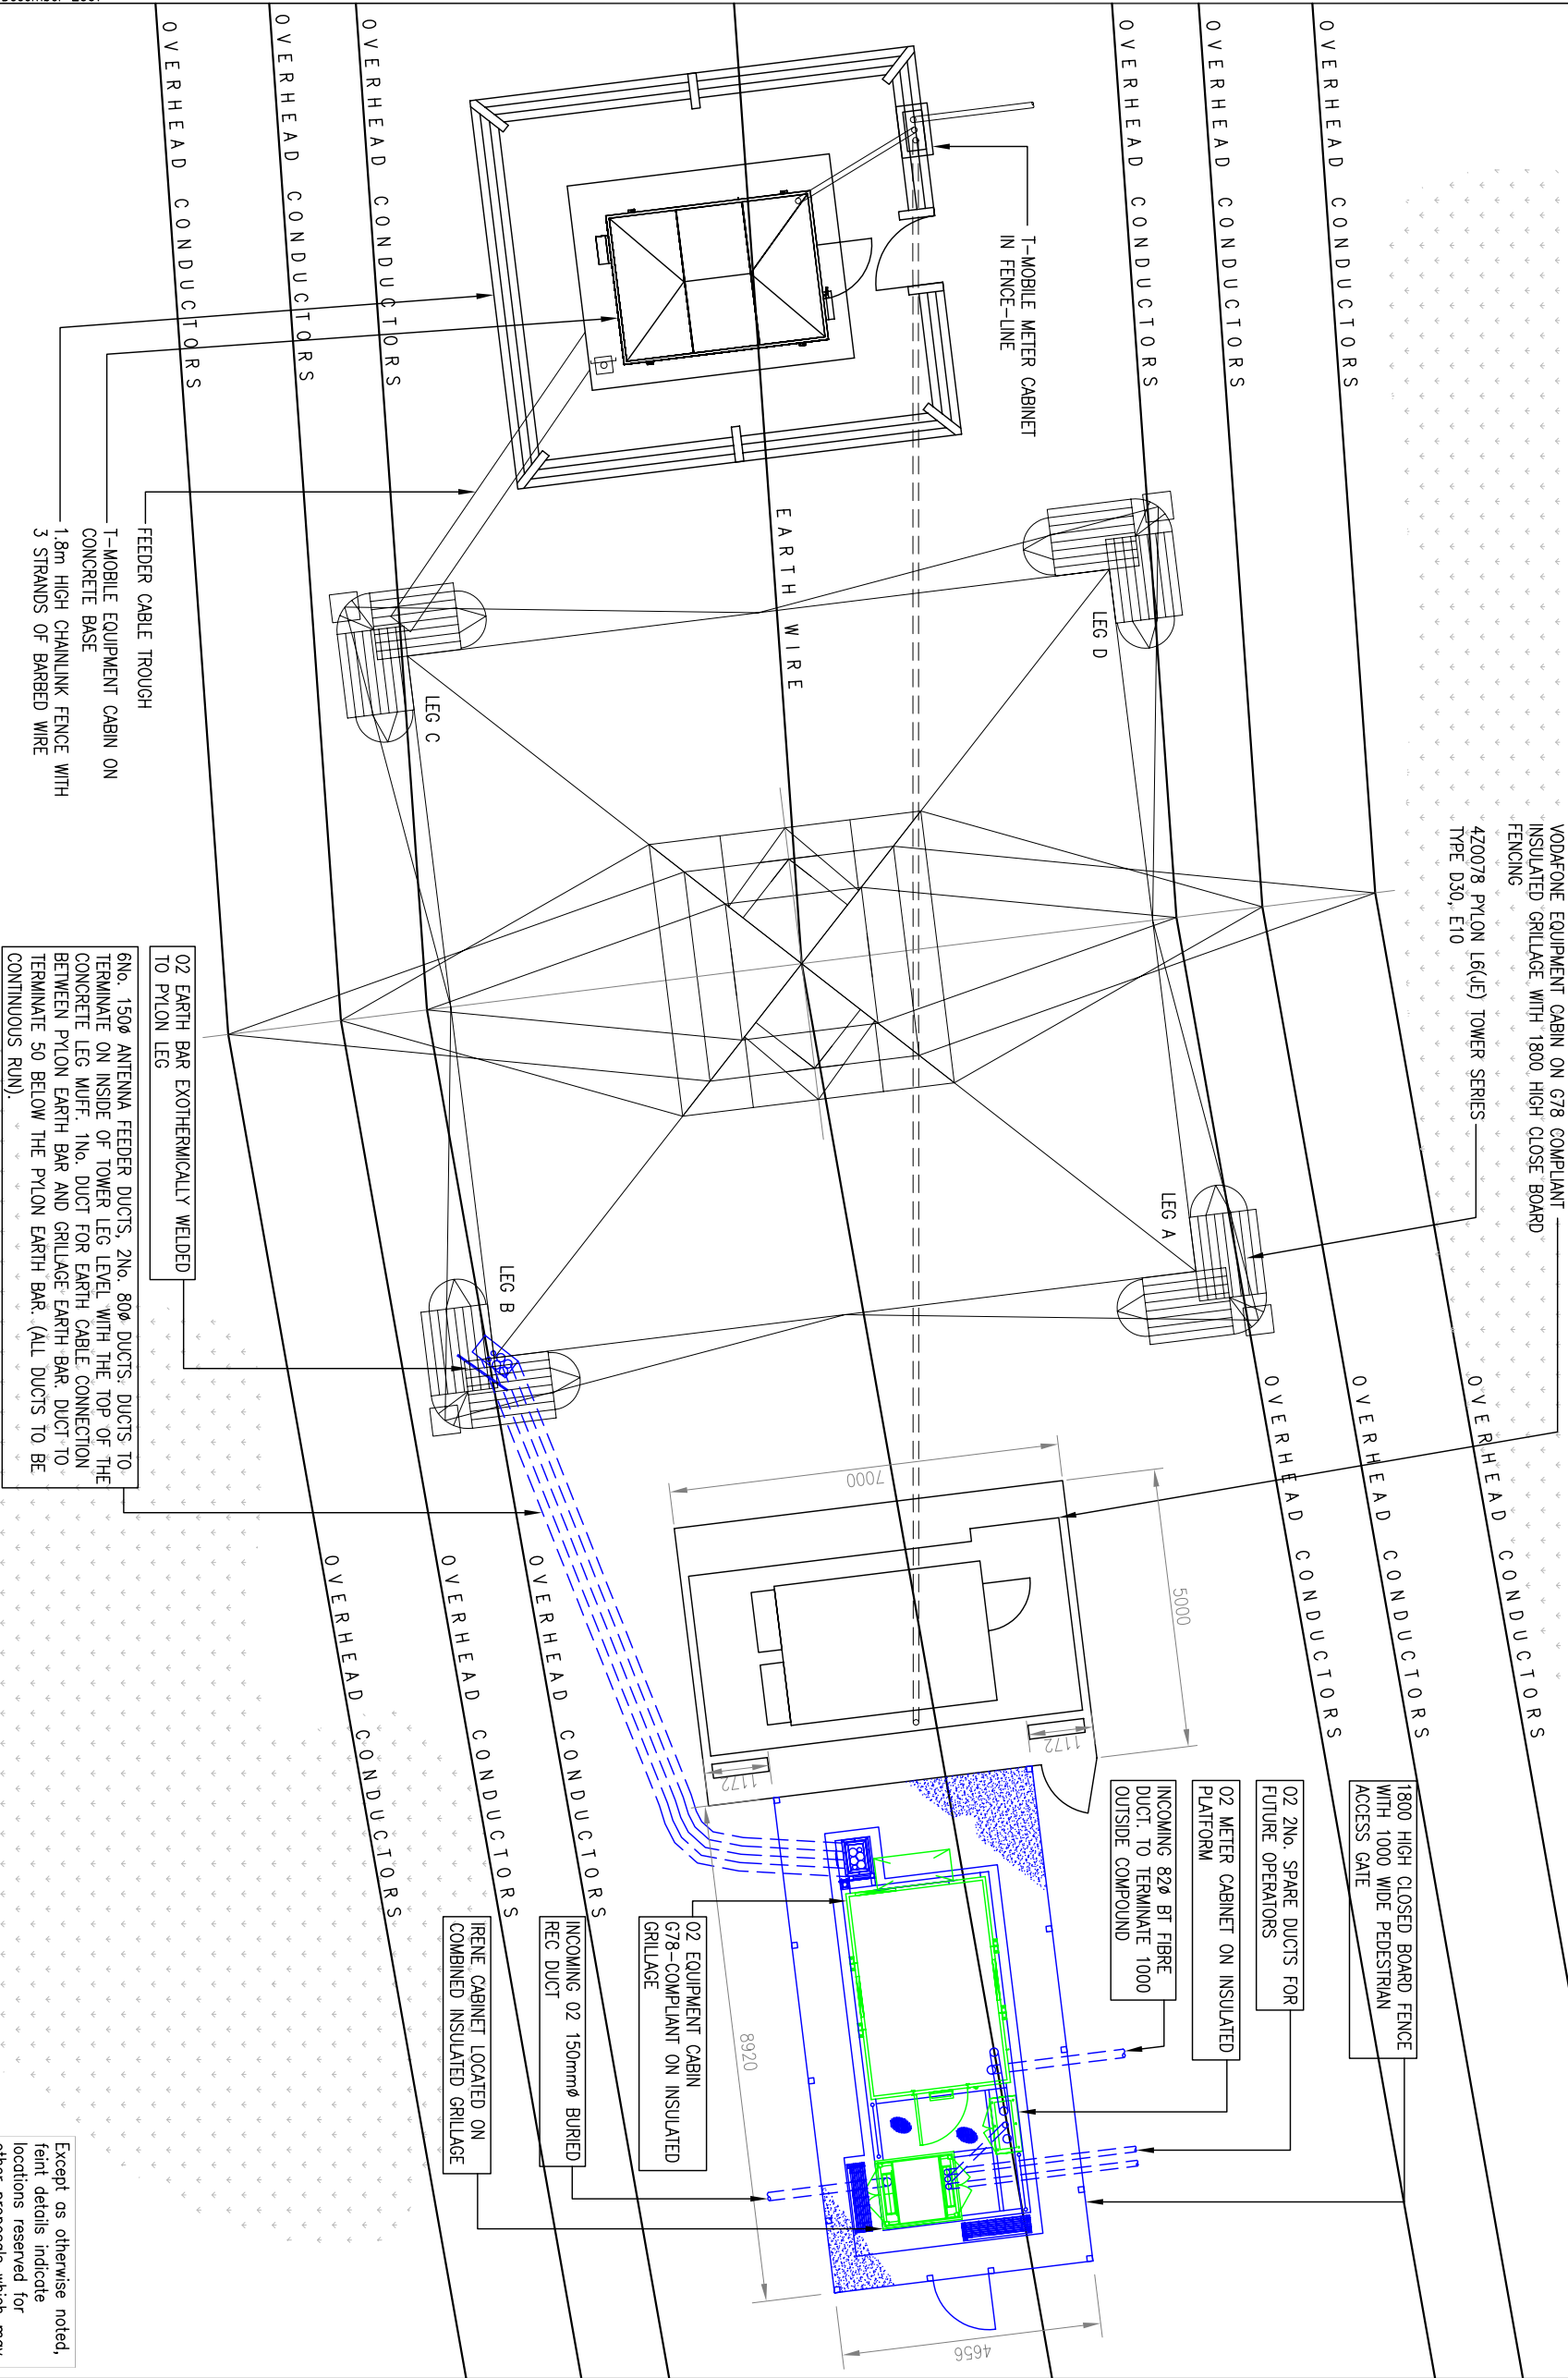

nationalgrid
Wireless

NOTES

- DO NOT SCALE DIMENSIONS EXCEPT FOR PLANNING PURPOSES
- ALL DIMENSIONS IN MILLIMETRES UNLESS STATED OTHERWISE
- ALL LEVELS ARE IN METRES AND RELATED TO A LOCAL DATUM

Contractor: National Grid Wireless
Consultant: In House

Engineer: CHRIS PERRY
01698 871026 chris.perry@ngridwireless.com
Drawing manager:

Project No.				
04	TEXT AMENDS	12.06.08	NA	CP
03	NEW APPLICATION	30.05.08	SP	NB
02	Feeder note modified	06.03.07	RHS	LB
01	Master file created	19.02.07	RHS	SF
Iss	Revision	Date	Dwn	App

This drawing is the property of National Grid Wireless and may not be reproduced or disclosed to a third party in any form without written permission

National Grid Wireless
Wireless House
Warwick Technology Park
Heathcote Lane
Warwick CV34 6DD
TEL: 01926 416000
FAX: 01926 416600

02 REF: 36683

02

SITE PLAN
PROPOSED

Scale: 1:125

Site no. 252158

site 420078 PYLON

name
PINFOLD LANE
ROYSTON LANE, BARNSELEY
SOUTH YORKSHIRE,
S71 4PL

Eastings and Northings
436263 410631

NGR: SE 36263 10631

Date: 19.02.07 Drn: RHS

TP/dtr	client_type	No_issue	App
P	SE6028_03_150_M04_04	SF	