


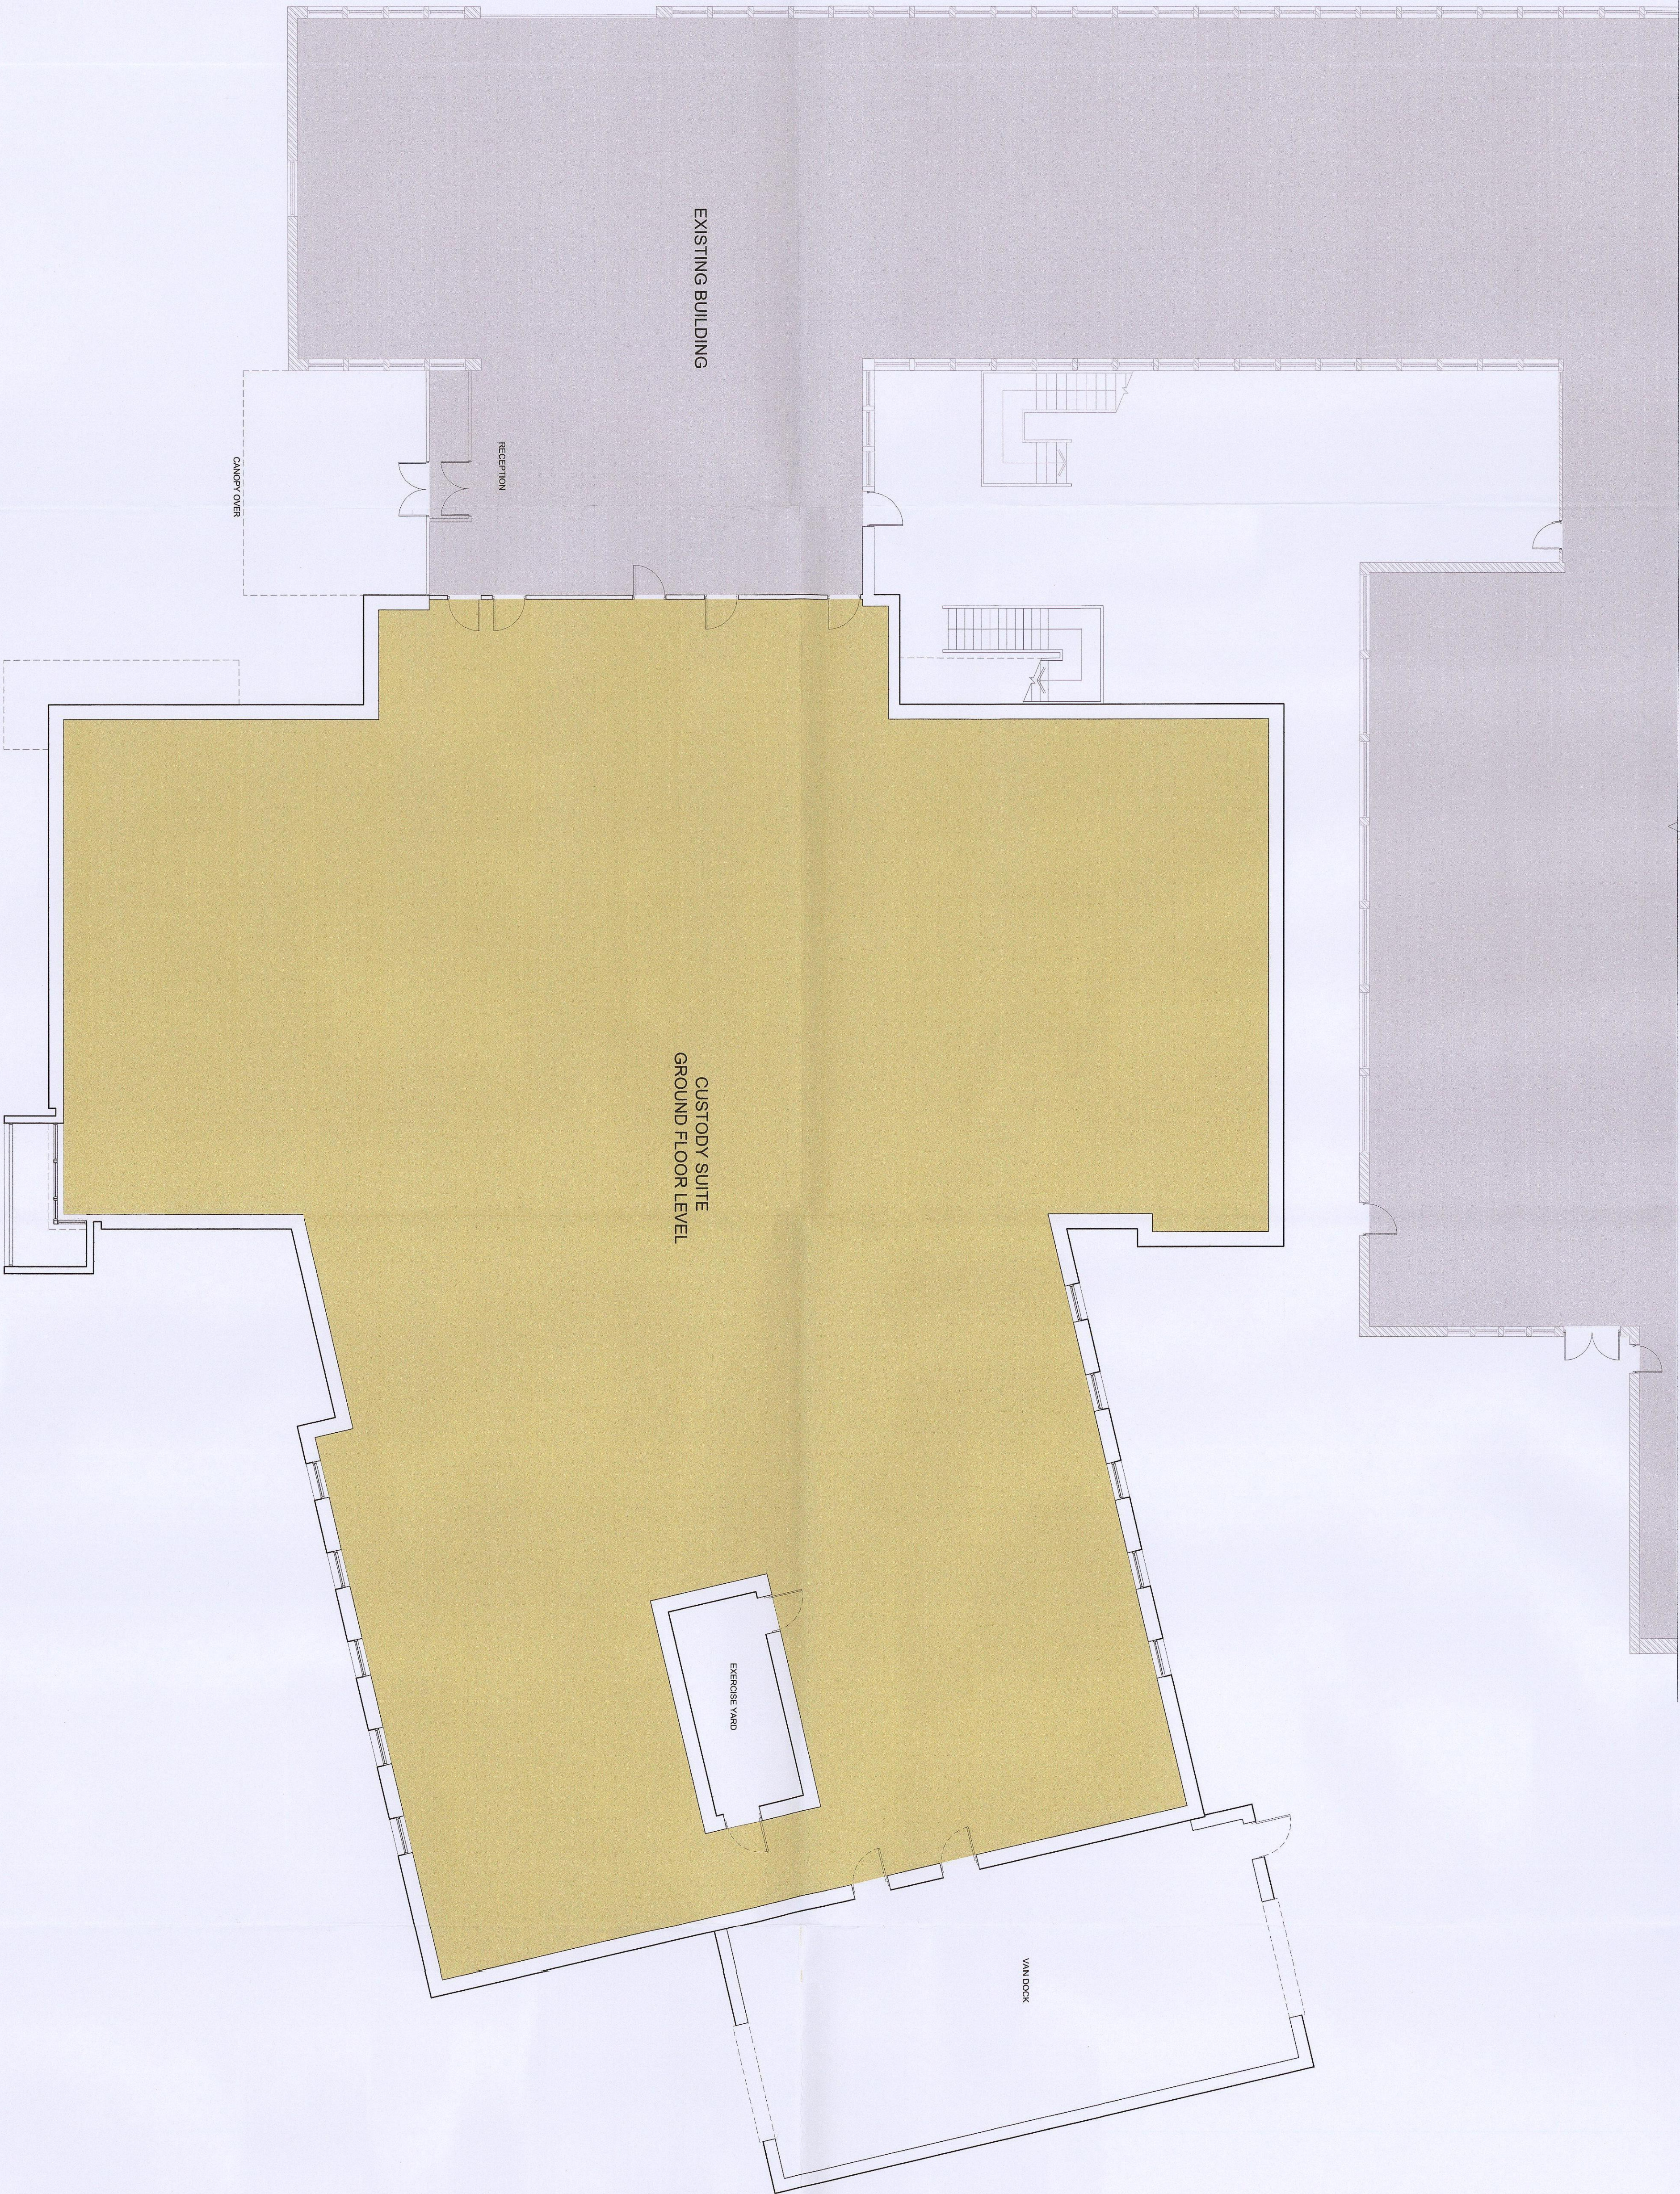

Received By: *[Signature]*
25 SEP 2014
CORPORATE MAIL ROOM
ORIGINAL COPY

- 11.08.14 Planning Issue.			VO	SC
Rev.	Draw	Locals	Drawn	Checked
Issued for: PLANNING				

Project/Client:	Project No:
South Yorkshire Police	IASR 13003900

Draw No:	113
Rev:	-

Drawing:		Scale:	@A1
Ground Floor Plan		Drawn By:	VG
Without Internal Layout		Date:	04.09.14
Checked By:	Date:	Checked By:	Date:
SC	04.09.14	SC	04.09.14

ARCHIAL | NORR