

Drawn by: MJB	Date: 15.06.12	Scale: 1:100	@ A1
Status	Preliminary	Preparation	Tender
Date:	15.06.12		
Approved by:	DC		
Revision		Date	Drawn
			Approved


Building D:
Specialist Open Unit for Severe Learning
Disabilities (LD)
&
Specialist Secure PICU Unit for Severe ASD
and/or LD

24 Beds (12 Mixed (6&6), 12 Mixed (6&6))

Medium Security


GIFA: Ground Floor:	1110m ²
First Floor:	197m ²

TOTAL: 1307m²

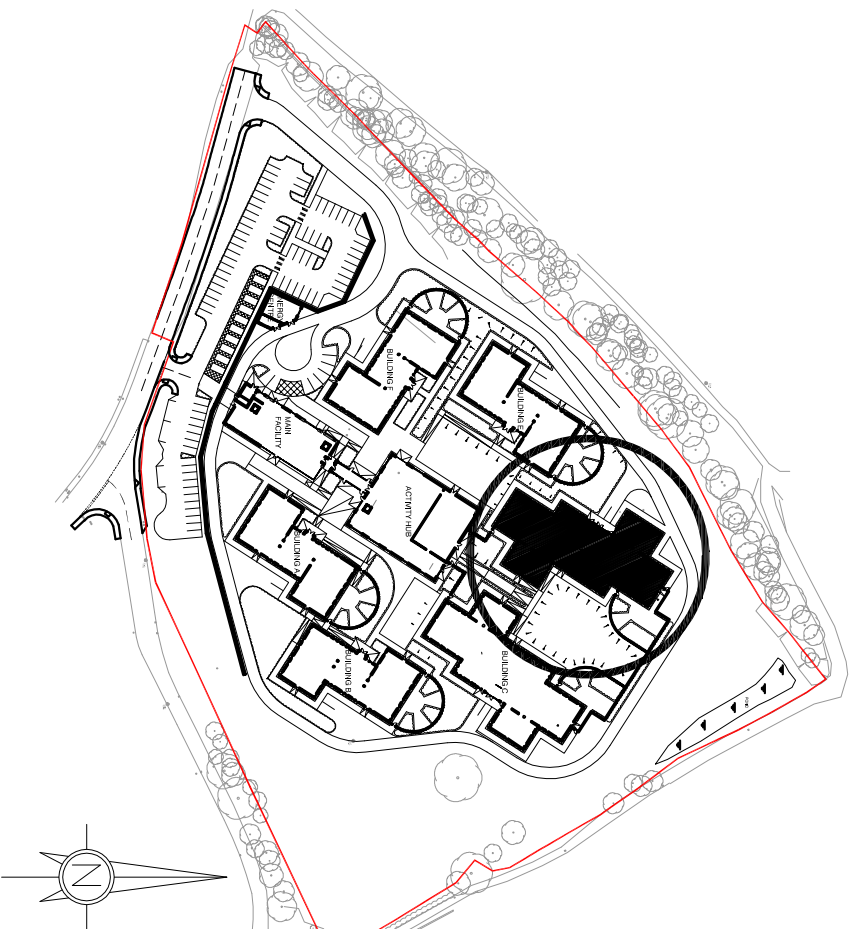

Building D - Location Plan Scale 1:2500

This drawing was prepared for Interserve Construction and shall not be used for any other purpose than for making a planning application to Barnsley Metropolitan Borough Council.

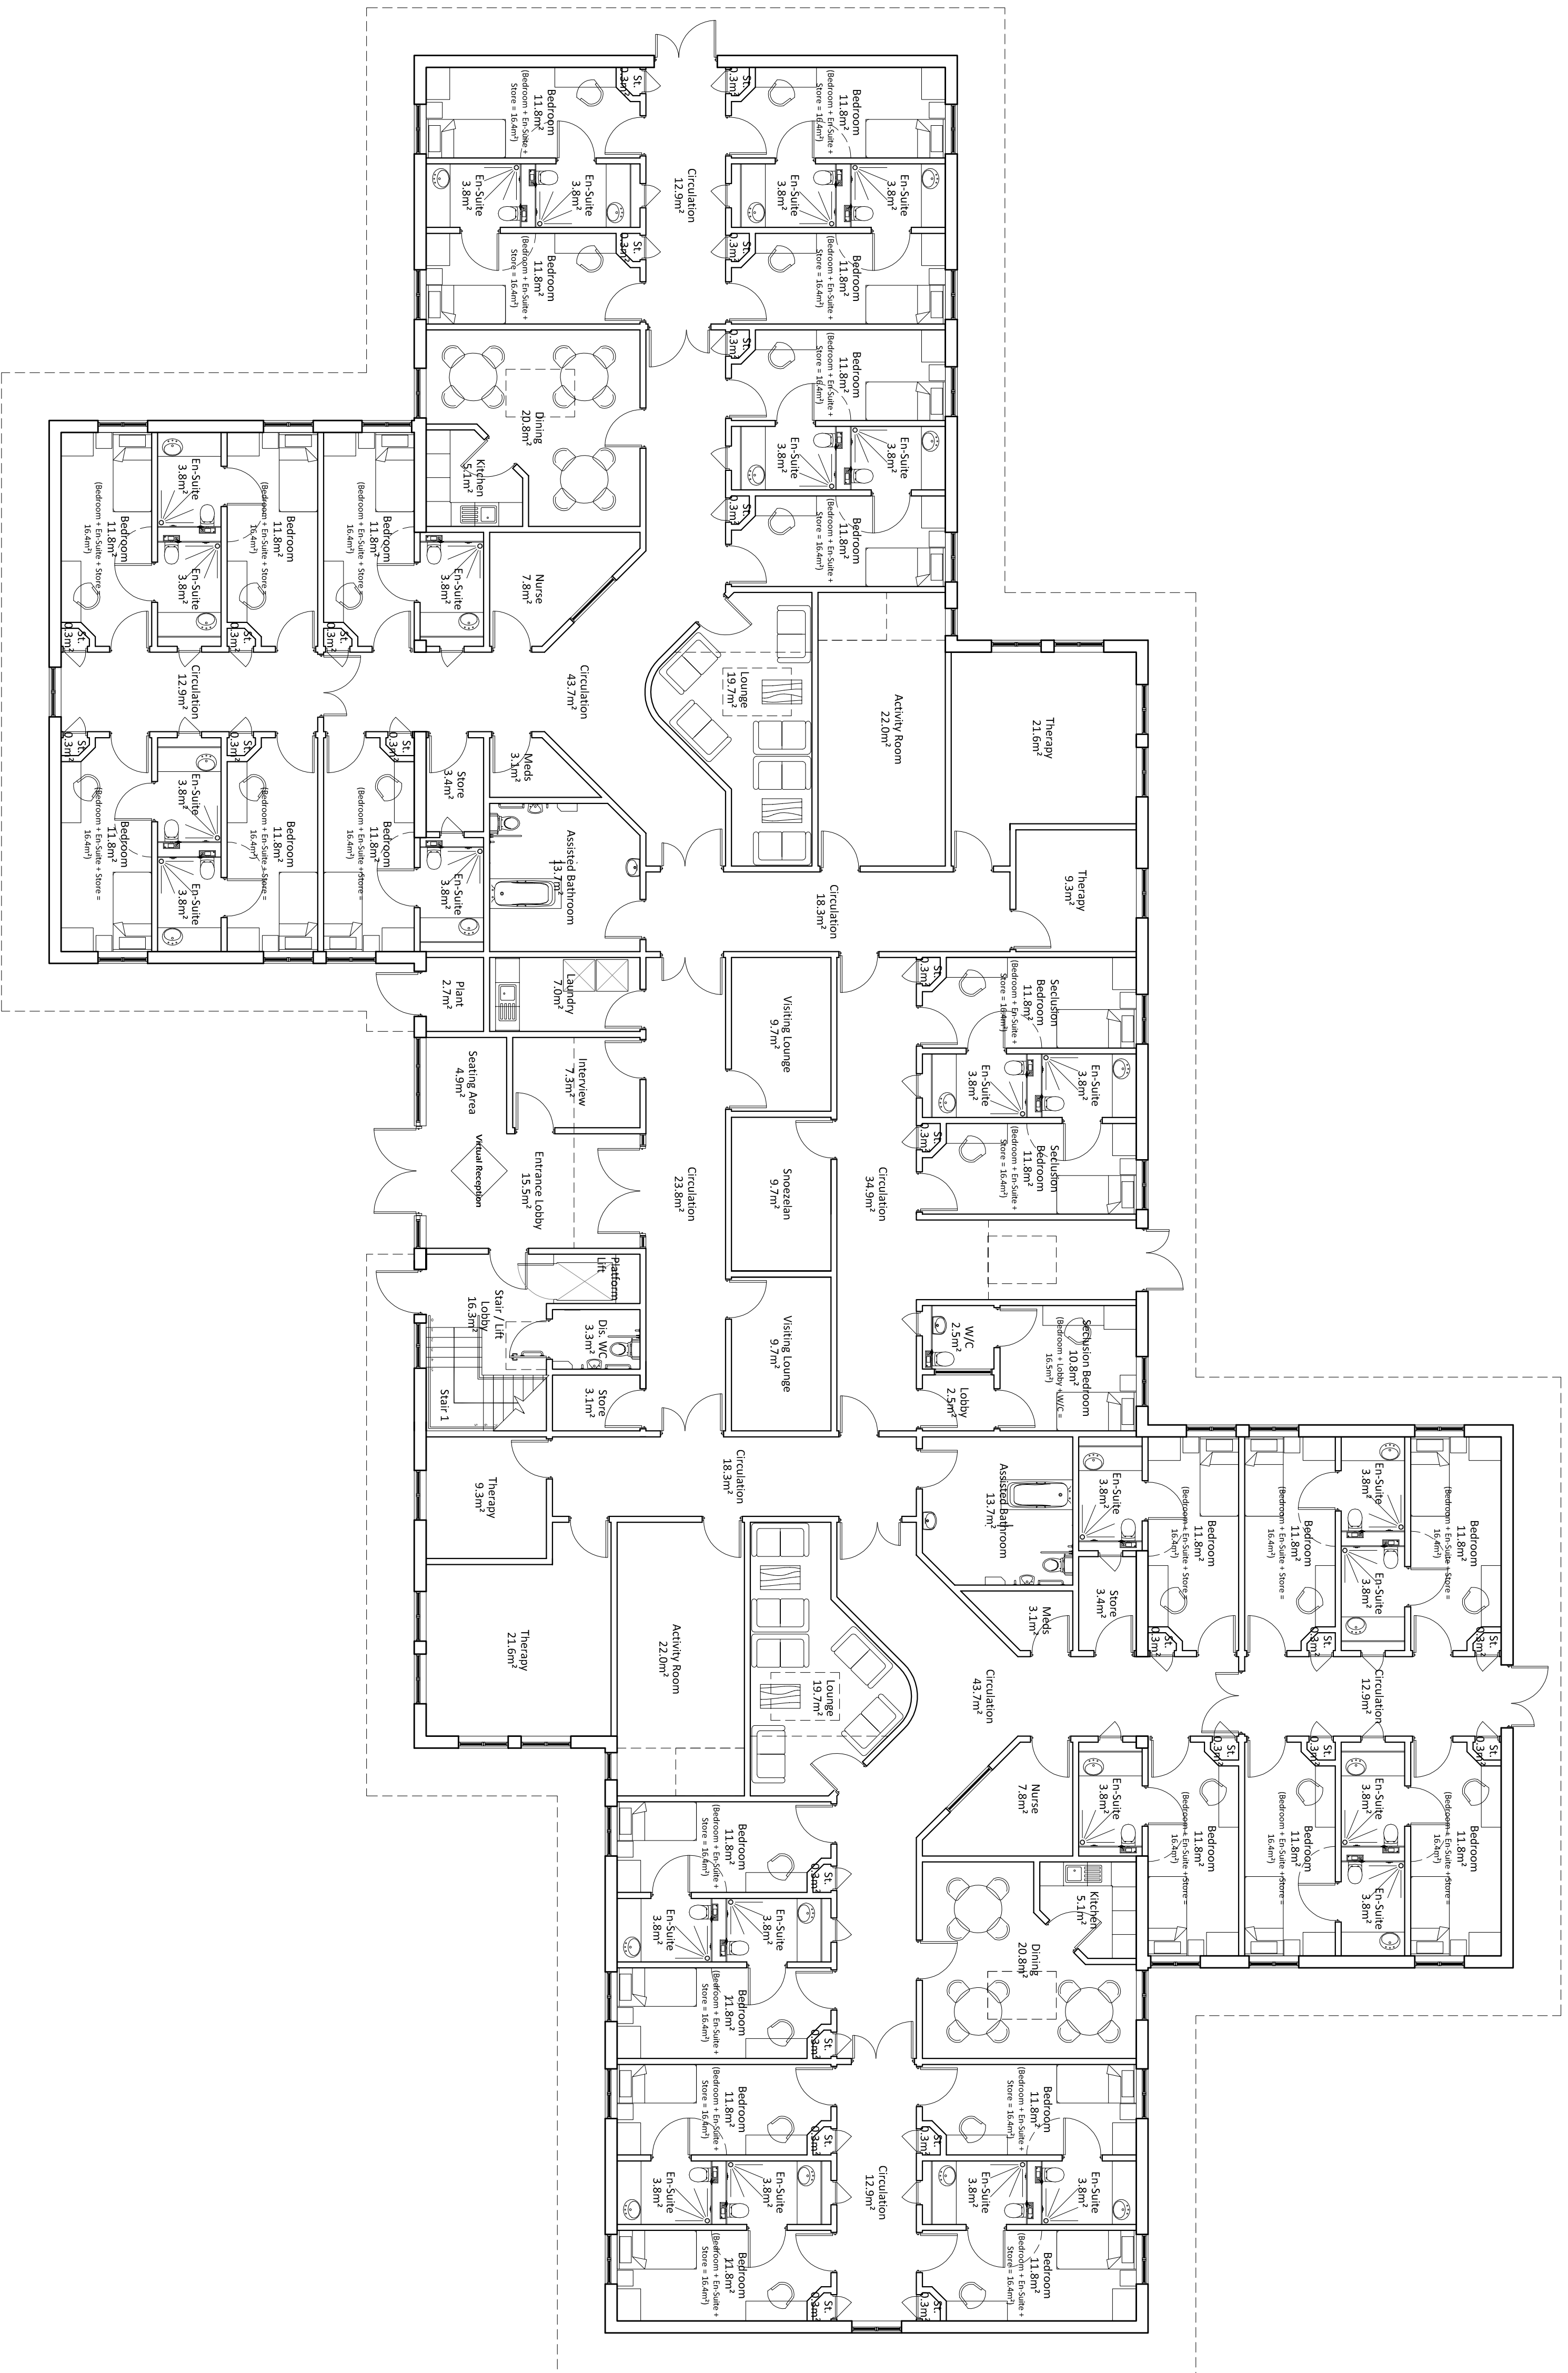

Building D - Ground Floor Plan Scale 1:100

Project: Hoyland Estates	Drawing Title: Building D Plans Severe LD. & Secure PICU / Severe ASD/LD
Project: Earlswood Autistic Hospital	
Project No.: 347-01	Drawing No.: (2-)11
Rev.: -	
RACE COTTAM ASSOCIATES	
Severus Studio 3 Winder House Oak Street Newark E17 4BB T: 014 273 7050 F: 014 273 7881	
website: www.racecottage.com	